

• 0.04 • 0.03 • 0.02 • 0.02 • 0.02 • 0.03 • 0.04 • 0.04 • 0.03 • 0.03 • 0.04 • 0.05 • 0.06 • 0.08 • 0.09 • 0.11 • 0.11 • 0.11 • 0.10 • 0.09 • 0.07 • 0.07 • 0.06 • 0.04 • 0.02 • 0.01 • 0.01 • 0.00 • 0.00 • 0.00 • 0.01 • 0.01 • 0.02 • 0.03 • 0.04 • 0.04 • 0.05 • 0.05 • 0.06 • 0.07 • 0.07 • 0.08 • 0.09 • 0.10 • 0.10 • 0.09 • 0.09 • 0.08 • 0.08 • 0.07 • 0.07


Section 1 - Vertical Readings

0.22 0.14 0.11 0.08 0.10 0.09 0.08 0.07 0.08 0.09 0.09 0.10 0.11 0.12 0.13 0.14 0.14 0.16 0.16 0.17 0.16 0.14 0.12 0.10 0.08 0.07 0.06 0.05 0.05 0.06 0.07 0.07 0.06 0.06 0.06 0.09 0.10 0.10 0.09 0.08

Section 2 - Vertical Readings

• 0.06 • 0.07 • 0.08 • 0.08 • 0.09 • 0.10 • 0.10 • 0.11 • 0.12 • 0.12 • 0.12 • 0.13 • 0.13 • 0.13 • 0.14 • 0.15 • 0.16 • 0.16 • 0.17 • 0.17 • 0.18 • 0.18 • 0.19 • 0.19 • 0.20 • 0.21 • 0.22 • 0.23 • 0.24 • 0.24 • 0.22 • 0.21


Section 3 - Vertical Readings

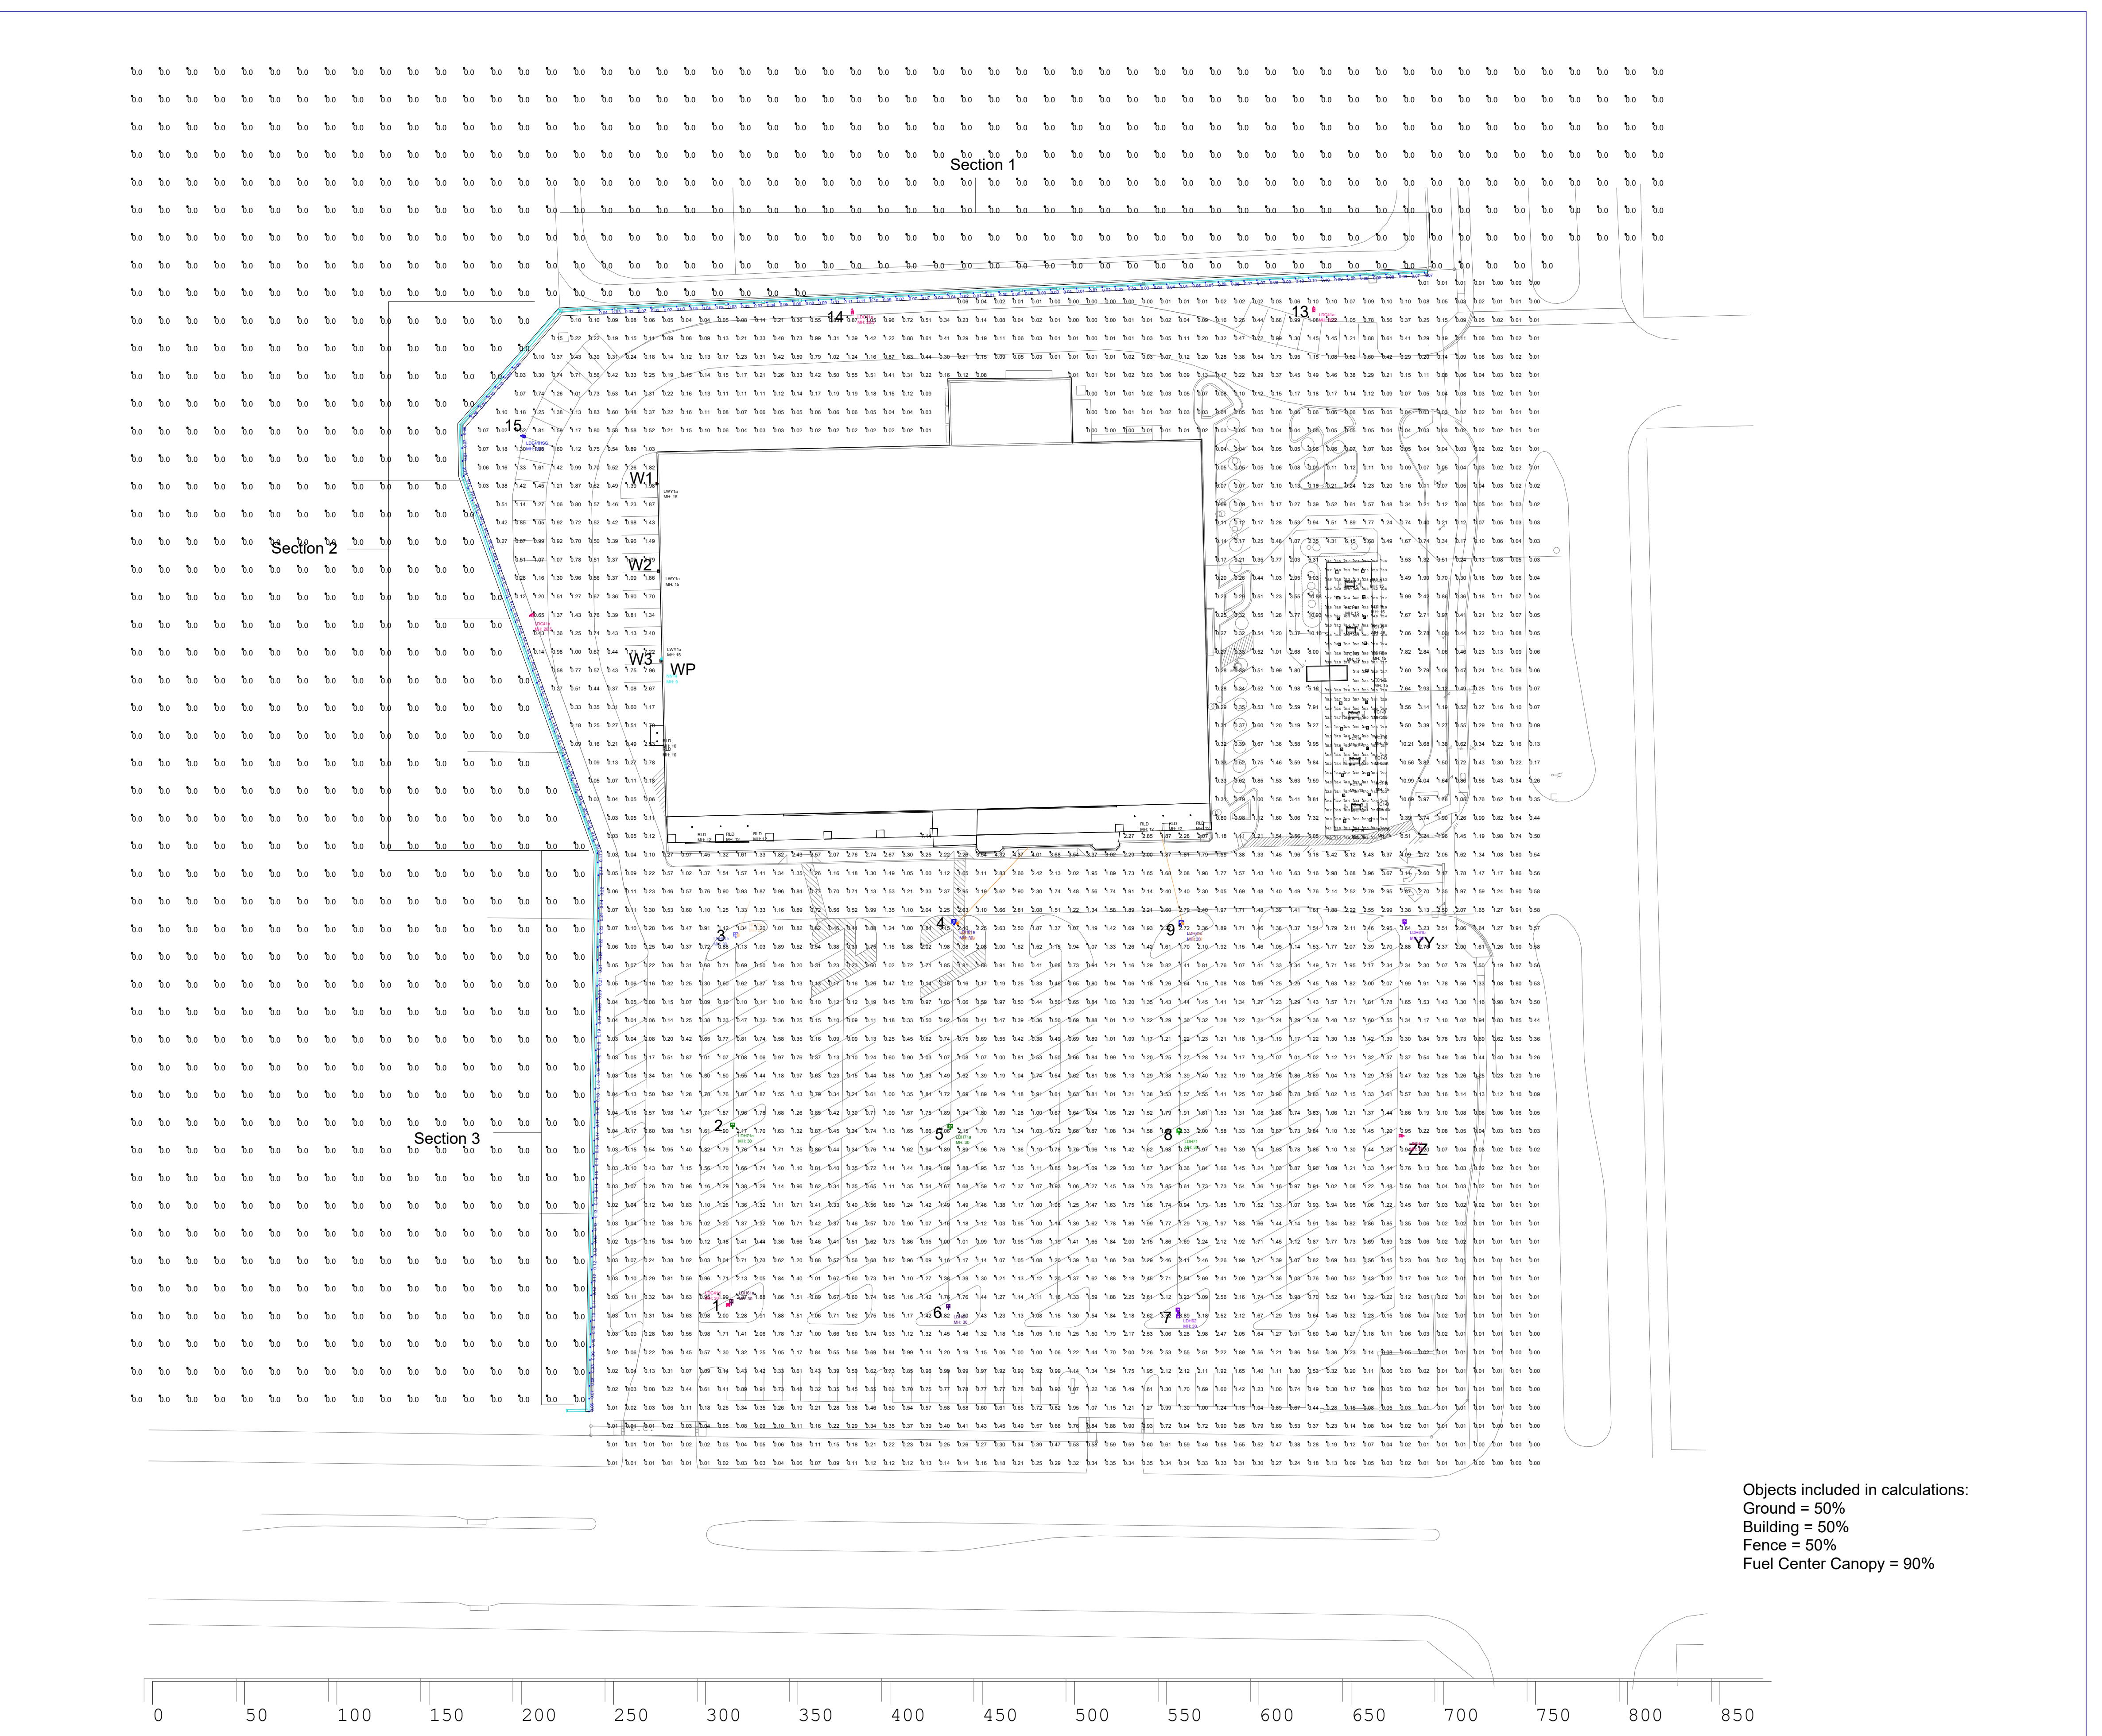

Luminaire Schedule				
Symbol	Qty	Label	Arrangement	Description
	21	FC1-B	Single	SCV-LED-10L-SC-50
	1	LDC41	Single	GLEON-SA4C-740-U-T2-HSS
	3	LDC41a	Single	GLEON-SA4C-740-U-T2R-HSS
	1	LDC41d	Single	GLEON-SA4C-740-U-T2-HS-GRSWH
	1	LDE41HSS	Single	GLEON-SA4C-740-U-SL4-HSS
	1	LDH61	SINGLE	GLEON-SA6C-740-VOLT-5MQ-BZ
	1	LDH61a	Single	GLEON-SA6C-740-U-5MQ-HS-GRSBK
	1	LDH61b	SINGLE	GLEON-SA6C-740-VOLT-5MQ-BZ
	1	LDH62	Back-Back	GLEON-SA6C-740-VOLT-5MQ-BZ
	1	LDH71	Single	GLEON-SA7C-740-U-5MQ
	2	LDH71a	Single	GLEON-SA7C-740-U-5MQ-HS-GRSBK
	1	LDH81a	Single	GLEON-SA8C-740-U-5MQ-HS-GRSBK
	1	LDH81b	Single	GLEON-SA8C-740-U-5MQ-HS-GRSBK
	1	LDH81c	GROUP	GLEON-SA8C-740-U-5MQ-BZ (2 HS-GRSBK)
	3	LWY1a	Single	GLEON-SA1C-740-U-AFL
	1	NFLD	Single	NFFLD-C25-D-UNV-66
	1	NFLDa	Single	NFFLD-C25-D-UNV-66
	1	NFLDb	Single	NFFLD-C25-D-UNV-66
	1	NN14	SINGLE	AXCS3A
	8	RLD	Single	8in Downlight Existing

Calculation Summary							
Label	CalcType	Units	Avg	Max	Min	Avg/Min	Max/Min
FUEL CENTER	Illuminance	Fc	31.54	50.5	10.3	3.06	4.90
SPILL LIGHT @ GRADE LEVEL	Illuminance	Fc	0.00	0.0	0.0	N.A.	N.A.
LEVELS ON WALL	Illuminance	Fc	0.10	0.2	0.0	N.A.	N.A.

Luminaire Location Summary				
Label	X	Y	Z	Orient
FC1-B	84.763	34.936	15	1.692
FC1-B	70.772	34.423	15	1.692
FC1-B	85.336	24.005	15	1.692
FC1-B	71.346	23.492	15	1.692
FC1-B	85.849	10.014	15	1.692
FC1-B	71.859	9.502	15	1.692
FC1-B	81.745	145.081	15	1.692
FC1-B	67.755	144.568	15	1.692
FC1-B	82.258	131.091	15	1.692
FC1-B	68.268	130.578	15	1.692
FC1-B	82.529	119.965	15	1.692
FC1-B	68.538	119.452	15	1.692
FC1-B	83.041	105.974	15	1.692
FC1-B	69.051	105.461	15	1.692
FC1-B	83.997	91.256	15	1.692
FC1-B	83.765	73.938	15	1.692
FC1-B	69.774	73.425	15	1.692
FC1-B	84.278	59.947	15	1.692
FC1-B	70.287	59.435	15	1.692
FC1-B	84.25	48.926	15	1.692
FC1-B	70.259	48.413	15	1.692
LDC41	104.046	-161.199	30	180
LDC41a	-195.277	287.214	26.5	273.828
LDC41a	54.989	288.452	26.5	273.523
LDC41a	-370.292	120.829	26.5	15.313
LDC41d	-262.438	-252.855	30	0
LDE41HSS	-374.917	218.607	26.5	341.567
LDH61	-143.039	-255.196	30	90
LDH61a	-260.677	-252.686	30	90
LDH61b	104.4	-46.736	30	90
LDH62	-18.588	-257.348	30	90
LDH71	-17.871	-160.154	30	90
LDH71a	-259.96	-156.926	30	90
LDH71a	-141.964	-157.644	30	90
LDH81a	-139.926	-46.591	30	90
LDH81b	-258.382	-53.56	30	90
LDH81c	-16.555	-47.208	30	0
LWY1a	-300.38	192.525	15	181.757
LWY1a	-299.338	145.126	15	181.757
LWY1a	-298.091	96.354	15	181.757
NFLD	-139.008	-46.879	29	46.931
NFLDa	-15.653	-47.283	29	103.585
NFLDb	-257.482	-53.56	29	70.538
NN14	-298.428	97.418	9	180
RLD	-300.947	57.336	10	0
RLD	-300.947	52.746	10	0
RLD	-26.525	12.506	12	0
RLD	-41.949	12.139	12	0
RLD	-11.715	12.672	12	0
RLD	-266.573	6.734	12	0
RLD	-281.997	6.367	12	0
RLD	-251.763	6.9	12	0

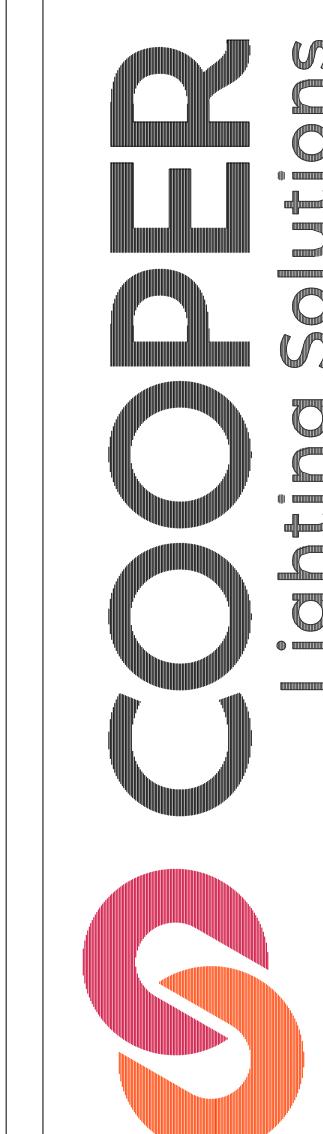

We make no representation as to its completeness, currency or accuracy because of reasons beyond our control. All digital CAD data appear to be extremely accurate, however, this apparent accuracy does not guarantee actual accuracy. The user of this data takes full responsibility for the accuracy and correctness of the data manually or with the use of a computer. This light level analysis is an estimate only, and locations based on specified light levels for exterior applications. Any variance from reflected light levels obtained. This analysis is a mathematical model and can be only as accurate as the calculated values may vary from actual measurements in certain situations due to variations in tolerances and application variances. The presence of objects will decrease light levels. Lighting application drawings are being provided to the recipient of this disclaimer.

The Kroger Company

David Sergeant

Project	Client:
Drawn By:	
Wendy Norman, LC	
Date:	
6/5/2023	
Scale:	
SCALE: 1" = 50'	
Project No:	
2101139B Fuel Center 6-5-23.AGI	