

			EXTERIOR FIN	NISH SCHEDULE		
TAG	MATERIAL	APPLICATION	MANUFACTURER	PRODUCT	COLOR/FINISH	DIMENSION
FINISH M	MATERIALS					
EF-1	EXTERIOR WOOD SIDING	FRONT FACADE EXTERIOR WALLS	NICHIHA FIBER CEMENT	VINTAGE WOOD AWP 3030	CEDAR	17-7/8" H x 119 5/16" L
EB-1	MODULAR BRICK	FRONT OF BUILDING	ACME BRICK	MODULAR BRICK	ROYAL BIRKDALE	7 5/8" x 2 1/4" x 3 5/8"
EB-2	MODULAR BRICK	ACCENT TOWER BRICK	INTERSTATE BRICK	MODULAR BRICK	MIDNIGHT BLACK	7 5/8" x 2 1/4" x 3 5/8"
EXTERIO	OR PAINTS					
EP-1	EXTERIOR PAINT	MAIN WALL SURFACE	SHERWIN WILLIAMS	ULTRA SPEC EXTERIOR LOW LUSTRE (N455)	SW 7627, WHITE HERON	
EP-2	EXTERIOR PAINT	PARAPET CAP	BENJAMIN MOORE	ULTRA SPEC EXTERIOR LOW LUSTRE (N455)	2125-30 GRAY SHOWER	
EP-3	EXTERIOR PAINT	DUMPSTER WALLS, REAR DOOR	BENJAMIN MOORE	ULTRA SPEC EXTERIOR LOW LUSTRE (N455)	HC-170 STONINGTON GREY	
EP-4	METAL PAINT	BOLLARDS	BENJAMIN MOORE	COROTECH HIGH SOLIDS RAPID DRY ENAMEL	SAFETY YELLOW	
EP-5	METAL PAINT	DUMPSTER GATES AND PYLON POLE	BENJAMIN MOORE	COROTECH HIGH SOLIDS RAPID DRY ENAMEL	FACTORY FINISH BLACK	
EP-6	ANTI-GRAFFITI COAT	EXTERIOR WALLS	BENJAMIN MOORE	ALIPHATIC ACRYLIC URETHANE - GLOSS	V500-00 CLEAR	
XTERIO	OR MISC.					
C-1	CANOPY - METAL	DRIVE-THRU CANOPY	BY MANUFACTURER	BY MANUFACTURER	2125-30 GRAY SHOWER	
C-2	CANOPY - METAL	BUILDING CANOPIES	BY MANUFACTURER	BY MANUFACTURER	2125-30 GRAY SHOWER	
S-1	SHUTTERS - POPPY	EXTERIOR WALLS REAR OF BUILDING	BY MANUFACTURER	BY MANUFACTURER	PROVIDED BY MANUFACTURER	
DP-1	DOOR	MAIN ENTRANCE DOORS	BY MANUFACTURER	BY MANUFACTURER	CLEAR ANODIZED	


	ISSUE	TABLE	
	No.	Date (mm/dd/yy)	Description
DIMENSION	01	01.17.2023	PLANNING REVIEW
8" H x 119 5/16" L			
' x 2 1/4" x 3 5/8"			
' x 2 1/4" x 3 5/8"			
	REVIS	IONS	
	No.	Date	Description
	DRAW	INGS REVIS	ED AS PER DESIGN BULLETIN
	No.	Date	Description








1 PROPOSE A5 SCALE: 1/4"=1' - 0" PROPOSED FRONT ELEVATION

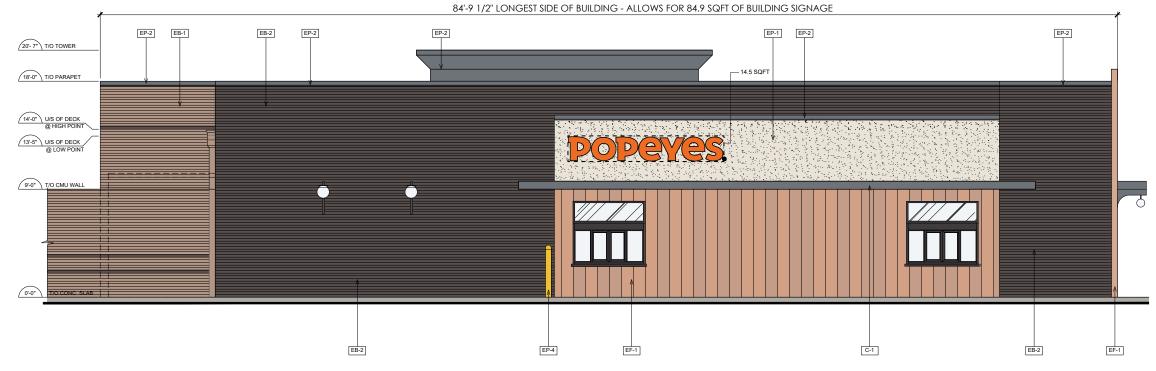

PROPOSED DT ELEVATION SCALE: 1/4"=1' - 0"

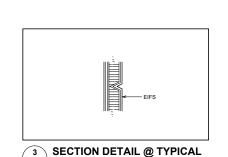

A5 SCALE: 2½"=1'-0" EIFS REVEAL

	LENGTH OF BUILDING	84'-9 1/2"
	ALLOWABLE SIGNAGE	84.75 SQFT
ı	PROVIDED SIGNAGE	62.30 SQFT

CVMDOL LECEND **GENERAL NOTES**

SEALANT / CAULKING AROUND DOOR / WINDOW FRAMES COLOUR: TO MATCH WINDOW / DOOR FRAMES THE CONTRACTOR SHALL BECOME FAMILIAR WITH AND FOLLOW ALL DRAWINGS AND SPECIFICATIONS

S Y IVIE	SOL LEGEND
1	NOTE REFERENCE REFER TO ELEVATION NOTES
FN#	FINISH TYPE

MATERIAL % PER ELEVATION						
	BRICK	EIFS	WOOD-LOOK PANEL	GLAZING		
FRONT	15%	45%	5%	35%		
DT	56%	17%	24%	3%		
REAR	87%	3%	10%	0%		
SIDE	65%	15%	0%	20%		
TOTAL	56%	20%	10%	14%		

EXTERIOR ELEVATION NOTES

- 1 PRE-FINISHED METAL CAP FLASHING C/W DRIP.
- G.C TO PROVIDE AND INSTALL DOUBLE LAYER OF REINFORCING MESH TO MIN. 2'-0" ABOVE GRADE AT ALL EIFS LOCATIONS (TYP.) IN ORDER TO ATTAIN ABUSE RESISTANCE STUCCO SYSTEM.
- 3 THINBRICK, COLOR: FLAGSTAFF. REFER TO POPEYES EXTERIOR FINISH SCHEDULE.
- 4 THIN BRICK, COLOR: WHITE WASH. REFER TO POPEYES EXTERIOR FINISH SCHEDULE.
- 5 EIFS. REFER TO POPEYES EXTERIOR FINISH SCHEDULE.
- 6 PRE-FINISHED 'BLACK ANODIZED' ALUMINUM STOREFRONT SYSTEM WITH INSULATED GLAZING
- 7 EXPOSED FOUNDATION TO BE PARGED AND FREE OF IMPERFECTIONS.
- 8 GAS UTILITY METER.
- 9 REFER TO STRUCTURAL DRAWINGS FOR FOUNDATION WALL AND FOOTING DETAILS.
- [10] INTERNALLY ILLUMINATED BUILDING SIGNAGE PROVIDED AND INSTALLED BY SIGN COMPANY. G.C TO PROVIDE AND INSTALL PEXTERIOR GRADE PRESSURE TREATED PLYWOOD BACKING AND ALL FINAL ELECTRICAL CONNECTION. SIGN MANUFACTURER SHALL OBTAIN STRUCTURALLY SEALED DRAWINGS AND SIGNAGE PERMITS FROM THE CITY BASED ON LOCAL REQUIREMENTS. G. SHALL VERIEY ACTUAL LOCATION & SIZE OF SIGNS WITH SIGN MANUFACTURERS APPROVED DRAWINGS AND COORDINATE LOCATION OF BLOCKING AND UTILITIES, G. OT O COORDINATE WITH SIGN NATALER TO USE VHM DRILL BIT WHILE DRILLING FOR ELECTRICAL FEED LINES AND SIGNAGE FASTENERS. ALL ELEMENTS PROVIDED BY SIGNAGE FABRICATOR TO BE REVIEWED AND APPROVED BY POPEYES PRIOR TO PRODUCTION
- 11 NON-ILLUMINATED BUILDING SIGNAGE PROVIDED AND INSTALLED BY SIGN COMPANY. G.C TO PROVIDE NON-ILLUMINATED BUILDING SIGNAGE PROVIDED AND INSTALLED BY SIGN COMPANY. G. TO PROVIDED AND INSTALLED BY SIGN COMPANY. G. TO PROVIDED AND INSTALLED BY SIGN MANUFACTURER SHALL OBTAIN STRUCTURALLY SEALED DRAWINGS AND SIGNAGE PERMITS FROM THE CITY BASED ON OCAL REQUIREMENTS. G. SHALL VERIEV A CITUAL LOCATION & SIZE OF SIGNS WITH SIGN MANUFACTURERS APPROVED BRAWINGS AND COORDINATE LOCATIONS OF BLOCKING AND UTILITIES G. TO COORDINATE WITH SIGN INSTALLER TO USE VIM POLIL BIT WHILE DRILLING FOR ELECTRICAL FEED LINES AND SIGNAGE FASTENERS. ALL ELEMENTS PROVIDED BY SIGNAGE FABRICATOR TO BE REVIEWED AND APPROVED BY POPEYES PRIOR TO PRODUCTION
- 12 NICHIHA VINTAGE WOOD, COLOR: CEDAR. REFER TO POPEYES EXTERIOR FINISH SCHEDULE
- [13] PROVIDE & INSTALL 6" DIAMETER STEEL PIPE BOLLARD TOP AT 4'-6" A.F.F. G.C. TO PAINT "SAFETY YELLOW". REFER TO POPEYES MASTER SCHEDULE.
- 14 DRIVE-THRU WINDOW. REFER TO DRIVE-THRU WINDOW SCHEDULE ON SHEET A11
- 15 N/A.
- [16] PRE-FINISHED GALVANIZED STEEL DOWNSPOUT & COLLECTOR BOX. G.C. TO COORDINATE WITH CIVIL ENGINEERS TO CONFIRM IF DOWNSPOUTS ARE SPLASHING ON CONCRETE PAD OR TIED TO THE STORM SEWER LINE. REFER TO PLUMBING DRAWINGS.
- 17 N/A.
- 18 DASHED LINE INDICATES T/O OF ROOF BEHIND PARAPET.
- 19 C/T CABINET AND METER.
- 20 LINE OF PARAPET WALLS BEYOND
- 21 GENERAL PURPOSE EXTERIOR LIGHTING FIXTURES 22 WALK-IN COOLER/FREEZER OUTLINE.
- 23 N/A.
- 25 ALL BASE FLASHING TO MATCH ADJACENT MATERIAL COLORS.
- | HOSE BIB. G.C. TO PAINT. COLOUR TO MATCH ADJACENT STUCCO COORDINATE EXACT LOCATION WITH G.C. REFER TO MECHANICAL DRAWINGS.
- 28 DECORATIVE PANELS SUPPLY AND INSTALL BY SIGN COMPANY.
- 29 G.C TO PROVIDE CONCRETE CURB ALONG DRIVE-THRU LANE. CURB TO PROJECT 8* FROM FACE OF PANELS AND LENGTH OF CURB IS EXTENT OF FEATURE WALL.
- 31 PRE-FABRICATED METAL BAND ABOVE DRIVE-THRU SUPPLY BY SIGN COMPANY AND INSTALL BY G.C. ALL CANOPIES IN WALL SUPPORT BY G.C. REFER TO STRUCTURAL DRAWINGS.
- 32 WALL SCONCE SUPPLY AND INSTALL BY SIGN COMPANY.
- 33 PRE-FABRICATED CANOPIES W/ PRE-WIRED RECESSED LIGHTS ABOVE DRIVE-THRU SUPPLY BY SIGN COMPANY AND INSTALL BY G.C. ALL CANOPIES IN WALL SUPPORT BY G.C. REFER TO STRUCTURAL DRAWINGS.
- 34 VERTICAL SIMULATED WOOD SLATS. REFER TO POPEYES EXTERIOR FINISH SCHEDULE.
- 35 WALL SCONCE LIGHTING. REFER TO ELECTRICAL SCHEDULE.
- 36 CONCRETE SIDEWALK (BY G.C). REFER TO SITE PLAN.
- HORIZONTAL WOOD GRAIN ENTRANCE CANOPY W/ TEAL VERTICAL & HORIZONTAL SUPPORTS SUPPLY BY SIGN COMPANY AND INSTALL BY G.C. PRE-WIRED LED LIGHT GLOBE FIXTURE.
- 39 PROVIDE EXTERIOR-GRADE PLASTER OVER CMU ENCLOSURE; PAINT PLASTER P-1



NOT FOR REGULATORY APPROVAL,

PERMITTING, or CONSTRUCTION GREG RYDEN, ARCHITECT DATE: 02/07/2023

ompany Logo

RYDEN ARCHITECTURE

713.993.6690 (o) ontact: greg ryden, aia



POPEYES.


US 2124 PROTOTYPE 2124-21

401 NORTHWESTERN DR.

COPPELL, TEXAS

EXTERIOR ELEVATIONS

ı	Drawn	Checked	S
l	GA	GR	
ı	Scale	Date	\vdash
		FEB 2023	/ES
	Project No.	Drawing No.	Įώ
	TBD	A5.0	P P

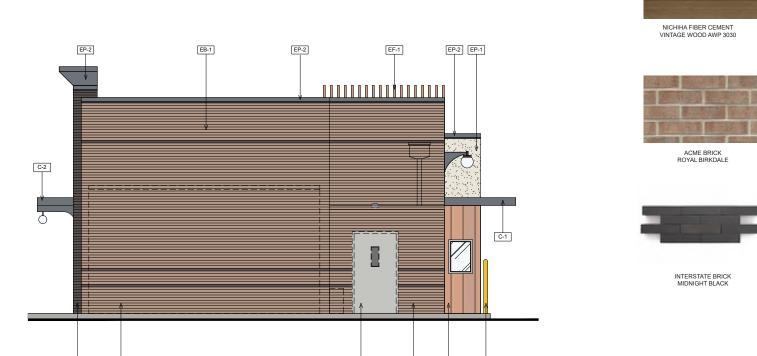

EB-1

EP-3

EF-1 EP-4

			EXTERIOR FIN	NISH SCHEDULE		
TAG	MATERIAL	APPLICATION	MANUFACTURER	PRODUCT	COLOR/FINISH	DIMENSION
FINISH M	IATERIALS					
EF-1	EXTERIOR WOOD SIDING	FRONT FACADE EXTERIOR WALLS	NICHIHA FIBER CEMENT	VINTAGE WOOD AWP 3030	CEDAR	17-7/8" H x 119 5/16
EB-1	MODULAR BRICK	FRONT OF BUILDING	ACME BRICK	MODULAR BRICK	ROYAL BIRKDALE	7 5/8" x 2 1/4" x 3 5
EB-2	MODULAR BRICK	ACCENT TOWER BRICK	INTERSTATE BRICK	MODULAR BRICK	MIDNIGHT BLACK	7 5/8" x 2 1/4" x 3 5
EXTERIO	R PAINTS					•
EP-1	EXTERIOR PAINT	MAIN WALL SURFACE	SHERWIN WILLIAMS	ULTRA SPEC EXTERIOR LOW LUSTRE (N455)	SW 7627, WHITE HERON	
EP-2	EXTERIOR PAINT	PARAPET CAP	BENJAMIN MOORE	ULTRA SPEC EXTERIOR LOW LUSTRE (N455)	2125-30 GRAY SHOWER	
EP-3	EXTERIOR PAINT	DUMPSTER WALLS, REAR DOOR	BENJAMIN MOORE	ULTRA SPEC EXTERIOR LOW LUSTRE (N455)	HC-170 STONINGTON GREY	
EP-4	METAL PAINT	BOLLARDS	BENJAMIN MOORE	COROTECH HIGH SOLIDS RAPID DRY ENAMEL	SAFETY YELLOW	
EP-5	METAL PAINT	DUMPSTER GATES AND PYLON POLE	BENJAMIN MOORE	COROTECH HIGH SOLIDS RAPID DRY ENAMEL	FACTORY FINISH BLACK	
EP-6	ANTI-GRAFFITI COAT	EXTERIOR WALLS	BENJAMIN MOORE	ALIPHATIC ACRYLIC URETHANE - GLOSS	V500-00 CLEAR	
EXTERIO	R MISC.					
C-1	CANOPY - METAL	DRIVE-THRU CANOPY	BY MANUFACTURER	BY MANUFACTURER	2125-30 GRAY SHOWER	
C-2	CANOPY - METAL	BUILDING CANOPIES	BY MANUFACTURER	BY MANUFACTURER	2125-30 GRAY SHOWER	
S-1	SHUTTERS - POPPY	EXTERIOR WALLS REAR OF BUILDING	BY MANUFACTURER	BY MANUFACTURER	PROVIDED BY MANUFACTURER	
DP-1	DOOR	MAIN ENTRANCE DOORS	BY MANUFACTURER	BY MANUFACTURER	CLEAR ANODIZED	








ON, GRAY SHOWER, AMS BENJAMIN MOORE

SHOWER, STONINGTON OF BENJAMIN MO

1 PROPOSED REAR ELEVATION A5.1 SCALE: 1/4"=1"-0"

EB-1

EB-2

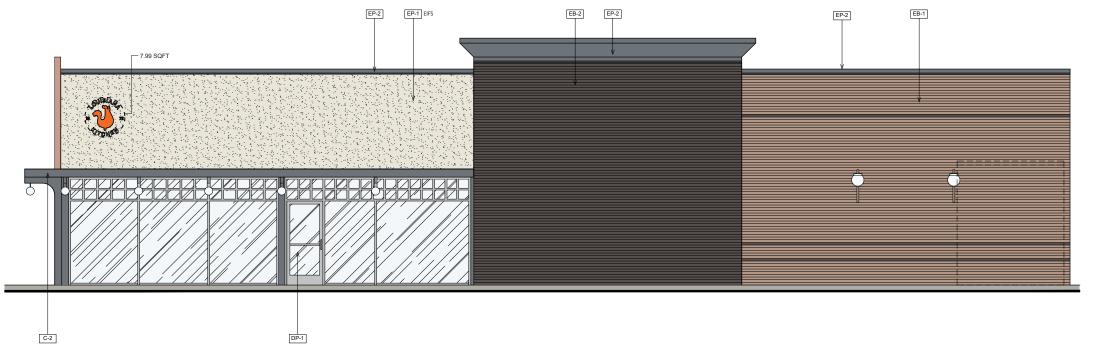

PROPOSED SIDE ELEVATION

A5.1) SCALE: 1/4"=1"-0"

GENERAL NOTES

- SEALANT / CAULKING AROUND DOOR / WINDOW FRAMES. COLOUR: TO MATCH WINDOW / DOOR FRAMES.
- 2. THE CONTRACTOR SHALL BECOME FAMILIAR WITH AND FOLLOW ALL DRAWINGS AND SPECIFICATIONS.

MATERIAL % PER ELEVATION							
	BRICK EIFS WOOD-LOOK PANEL GLAZING						
FRONT	15%	45%	5%	35%			
DT	56%	17%	24%	3%			
REAR	87%	3%	10%	0%			
SIDE	65%	15%	0%	20%			
TOTAL	56%	20%	10%	14%			

EXTERIOR ELEVATION NOTES

- 1 PRE-FINISHED METAL CAP FLASHING C/W DRIP.
- G.C TO PROVIDE AND INSTALL DOUBLE LAYER OF REINFORCING MESH TO MIN. 2-0" ABOVE GRADE AT ALL EIFS LOCATIONS (TYP.) IN ORDER TO ATTAIN ABUSE RESISTANCE STUCCO SYSTEM.
- 3 THINBRICK, COLOR: FLAGSTAFF. REFER TO POPEYES EXTERIOR FINISH SCHEDULE.
- 4 THIN BRICK, COLOR: WHITE WASH. REFER TO POPEYES EXTERIOR FINISH SCHEDULE.
- 5 EIFS. REFER TO POPEYES EXTERIOR FINISH SCHEDULE.
- 6 PRE-FINISHED 'BLACK ANODIZED' ALUMINUM STOREFRONT SYSTEM WITH INSULATED GLAZING.
- 7 EXPOSED FOUNDATION TO BE PARGED AND FREE OF IMPERFECTIONS.
- 8 GAS UTILITY METER.
- 9 REFER TO STRUCTURAL DRAWINGS FOR FOUNDATION WALL AND FOOTING DETAILS.
- [10] INTERNALLY ILLUMINATED BUILDING SIGNAGE PROVIDED AND INSTALLED BY SIGN COMPANY. G.C TO PROVIDE AND INSTALL IT EXTERIOR GRADE PRESSURE TREATED PLYWOOD BACKING AND ALL FINAL ELECTRICAL CONNECTION. SIGN MANUFACTURERS HALL DETAIN SINCULTURALLY SEALED DRAWINGS AND SIGNAGE PERMITS FROM THE CITY BASED ON LOCAL REQUIREMENTS. G. SHALL VERIFY ACTUAL LOCATION & SIZE OF SIGNS WITH SIGN MANUFACTURERS APPROVED PRAWINGS AND COORDINATE LOCATIONS OF BLOCKING AND UTILITIES. G.C TO COORDINATE WITH SIGN INSTALLER TO USE VHM DRILL BIT WHILE DRILLING FOR ELECTRICAL FEED LINES AND SIGNAGE FASTENERS. ALL ELEMENTS PROVIDED BY SIGNAGE FABRICATOR TO BE REVIEWED AND APPROVED BY POPEYES PRIOR TO PRODUCTION
- 11) NON-ILLUMINATED BUILDING SIGNAGE PROVIDED AND INSTALLED BY SIGN COMPANY. G.C. TO PROVIDE AND INSTALL \(^2\) EXTERIOR GRADE PRESSURE TREATED PLYWOOD BACKING. SIGN MANUFACTURER SHALL OBTAIN STRUCTUREALLY SEALE DO RAWINGS AND SIGNAGE PERMITS FROM THE CITY BASED ON LOCAL REQUIREMENTS. G.C. SHALL VERIEY ACTUAL LOCATION & SUZE OF SIGNS WITH SIGN MANUFACTURERY SHOPOVED DRAWINGS AND COORDINATE LOCATIONS OF BLOCKNOK AND UTILITIES. G.C. TO COORDINATE WITH SIGN INSTALLER TO USE VHM DRILL BIT WHILE DRILLING FOR ELECTRICAL FEED LINES AND SIGNAGE FASTRICATOR TO BE REVEWED AND APPROVED BY POPEYES PRIOR TO PRODUCTION
- 12 NICHIHA VINTAGE WOOD, COLOR: CEDAR. REFER TO POPEYES EXTERIOR FINISH SCHEDULE.
- 13 PROVIDE & INSTALL 6" DIAMETER STEEL PIPE BOLLARD TOP AT 4-6" A.F.F. G.C. TO PAINT "SAFETY YELLOW". REFER TO POPEYES MASTER SCHEDULE.
- 14 DRIVE-THRU WINDOW. REFER TO DRIVE-THRU WINDOW SCHEDULE ON SHEET A11.
- 15 N/A.
- | PRE-FINISHED GALVANIZED STEEL DOWNSPOUT & COLLECTOR BOX. G.C. TO COORDINATE WITH CIVIL ENGINEERS TO CONFIRM IF DOWNSPOUTS ARE SPEASHING ON CONCRETE PAD OR TIED TO THE STORM SEWER LINE. REFER TO PLUMBING DRAWINGS.
- 17 N/A.
- 18 DASHED LINE INDICATES T/O OF ROOF BEHIND PARAPET.
- 19 C/T CABINET AND METER.
- 20 LINE OF PARAPET WALLS BEYOND.
- GENERAL PURPOSE EXTERIOR LIGHTING FIXTURES.
 WALK-IN COOLER/FREEZER OUTLINE.
- 23 N/A.
- 24 N/A.
- 25 ALL BASE FLASHING TO MATCH ADJACENT MATERIAL COLORS.
- HOSE BIB. G.C. TO PAINT. COLOUR TO MATCH ADJACENT STUCCO COORDINATE EXACT LOCATION WITH G.C. REFER TO MECHANICAL DRAWINGS.
- 27 N/A.
- 28 DECORATIVE PANELS SUPPLY AND INSTALL BY SIGN COMPANY.
- 29 G.C TO PROVIDE CONCRETE CURB ALONG DRIVE-THRU LANE. CURB TO PROJECT 8" FROM FACE OF PANELS AND LENGTH OF CURB IS EXTENT OF FEATURE WALL.
- 30 N/A.
- 31 PRE-FABRICATED METAL BAND ABOVE DRIVE-THRU SUPPLY BY SIGN COMPANY AND INSTALL BY G.C. ALL CANOPIES IN WALL SUPPORT BY G.C. REFER TO STRUCTURAL DRAWINGS.
- 32 WALL SCONCE SUPPLY AND INSTALL BY SIGN COMPANY.
- 33 PRE-FABRICATED CANOPIES W/ PRE-WIRED RECESSED LIGHTS ABOVE DRIVE-THRU SUPPLY BY SIGN COMPANY AND INSTALL BY G.C. ALL CANOPIES IN WALL SUPPORT BY G.C. REFER TO STRUCTURAL DRAWINGS.
- 34 VERTICAL SIMULATED WOOD SLATS. REFER TO POPEYES EXTERIOR FINISH SCHEDULE.
- 35 WALL SCONCE LIGHTING. REFER TO ELECTRICAL SCHEDULE.
- 36 CONCRETE SIDEWALK (BY G.C). REFER TO SITE PLAN.
- HORIZONTAL WOOD GRAIN ENTRANCE CANOPY W/ TEAL VERTICAL & HORIZONTAL SUPPORTS SUPPLY BY SIGN COMPANY AND INSTALL BY G.C. PRE-WIRED LED LIGHT GLOBE FIXTURE.
- 38 _{N/A}.
- 39 PROVIDE EXTERIOR-GRADE PLASTER OVER CMU ENCLOSURE; PAINT PLASTER P-1
- [40] CMU ENCLOSURE WITH PLASTER APPLIED TO EXTERIOR OF ENCLOSURE WITH A SMOOTH CONTINUOUS SURFACE. PAINT PLASTER EP-1. REFER TO A1 FOR ENCLOSURE DIMENSIONS



PROJECT NORTI

THE CONTRACTOR IS TO VERIFY ALL DIMENSIONS AND CONDITIONS ON THE PROJECT AND TO REPORT ANY DISCREPANCIES TO THE POPEYES LOUISIAN. KITCHEN REPRESENTATIVE PRIOR TO COMMENCING WORK. THESE DRAWINI ARE NOT TO BE USED FOR CONSTRUCTION PURPOSES UNLESS INDICATED B

NOT FOR REGULATORY APPROVAL, PERMITTING, or CONSTRUCTION

GREG RYDEN, ARCHITECT
DATE: 02/07/2023

ompany Logo

RYDEN ARCHITECTURE

909 wakefield drive houston, texas 77018 713.993.6690 (o)

713.993.6690 (o) contact: greg ryden, aia



POPEYES,

US 2124 PROTOTYPE 2124-21

401 NORTHWESTERN DR.

COPPELL, TEXAS 75019

Drawing Title

EXTERIOR ELEVATIONS

Drawn	Checked	15
GA	GR	5
Scale	Date	_
	FEB 2023	SIZ.
Project No.	Drawing No.	Įμ
TBD	A5.1	POP
	GA Scale Project No.	GA GR Scale Date FEB 2023 Project No. Drawing No.